



A2.01 - FLOOR PLAN FIRE STATION 2

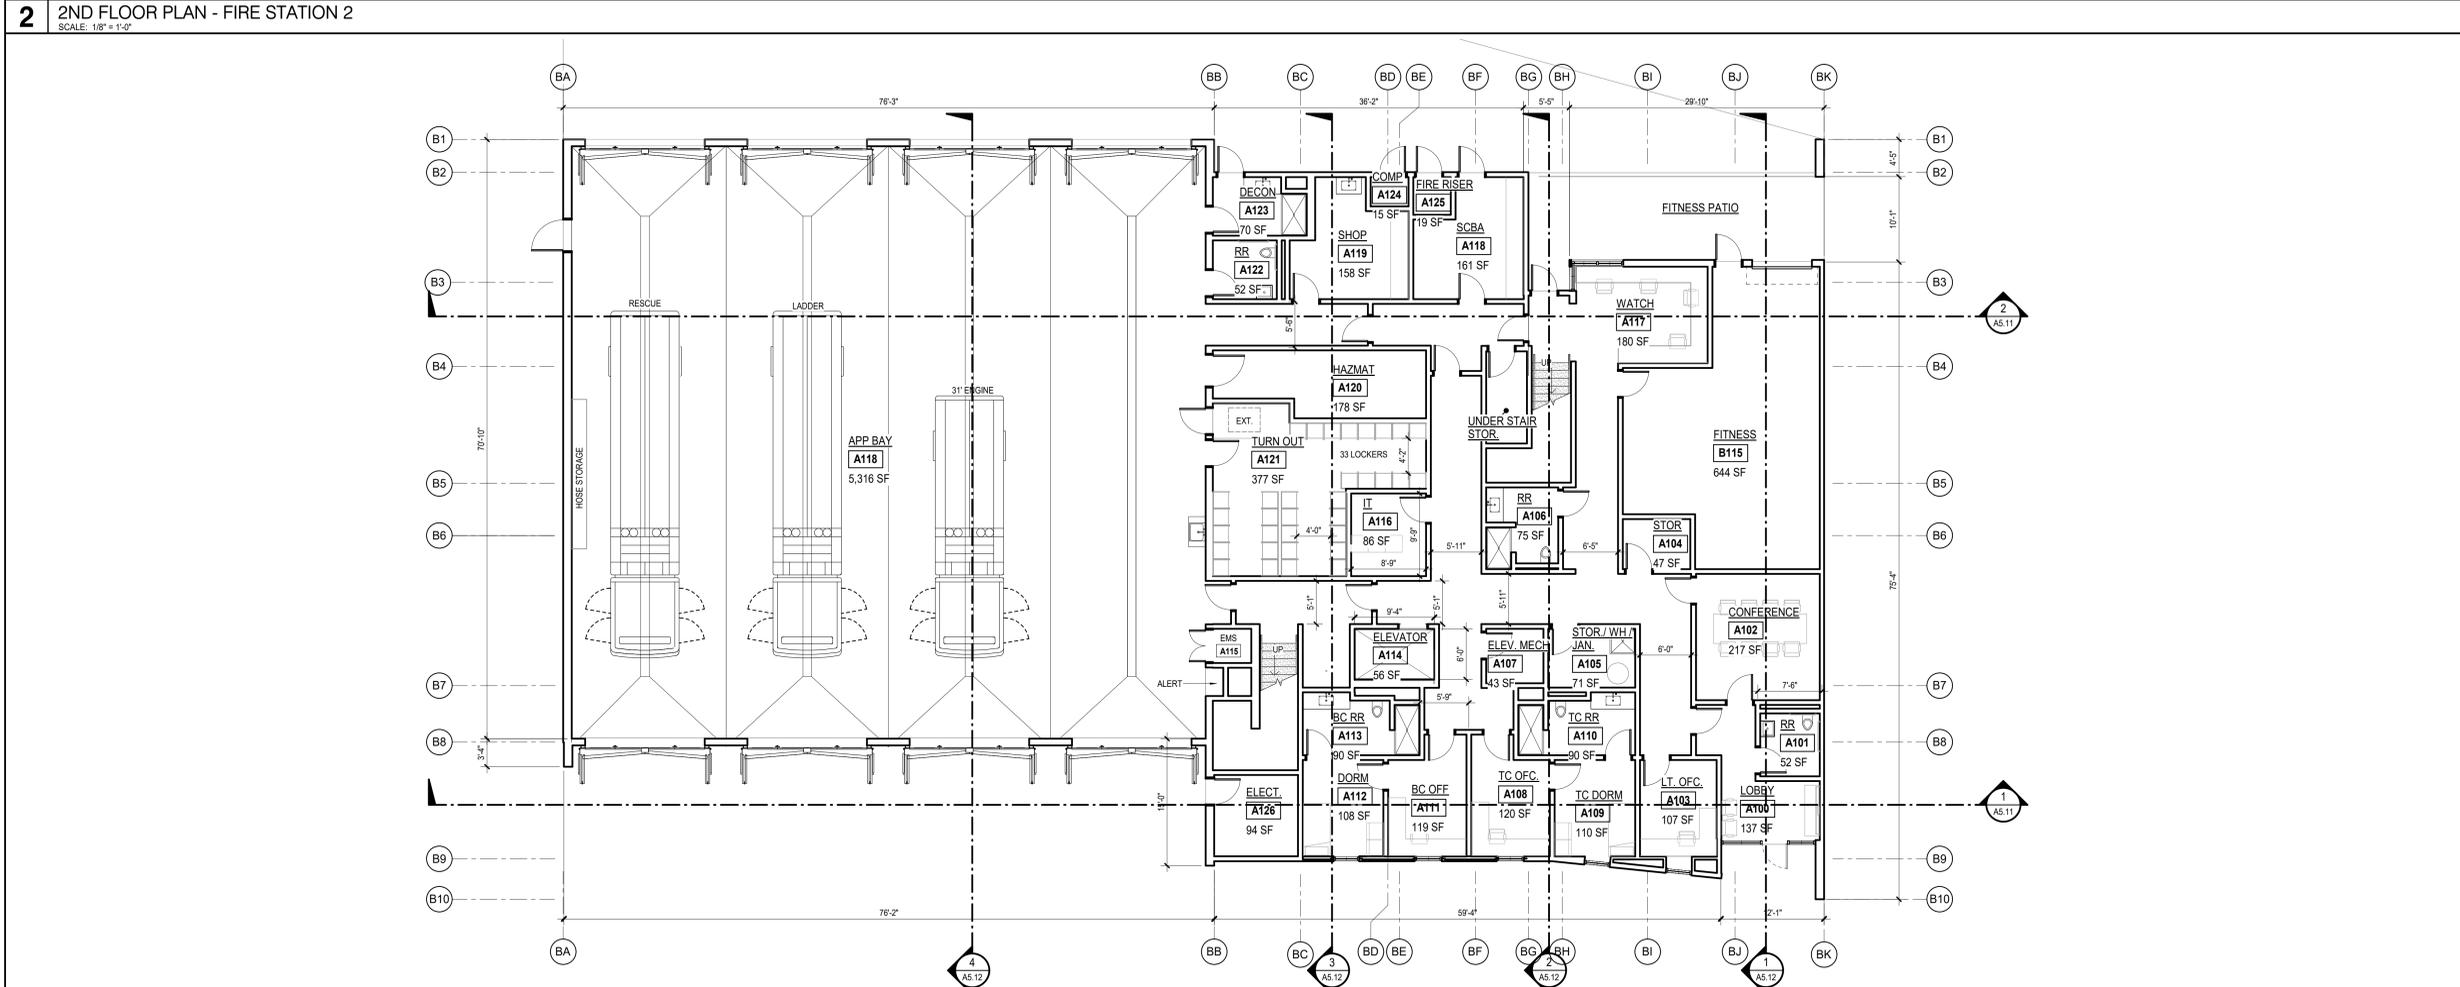


Not for permitting or construction

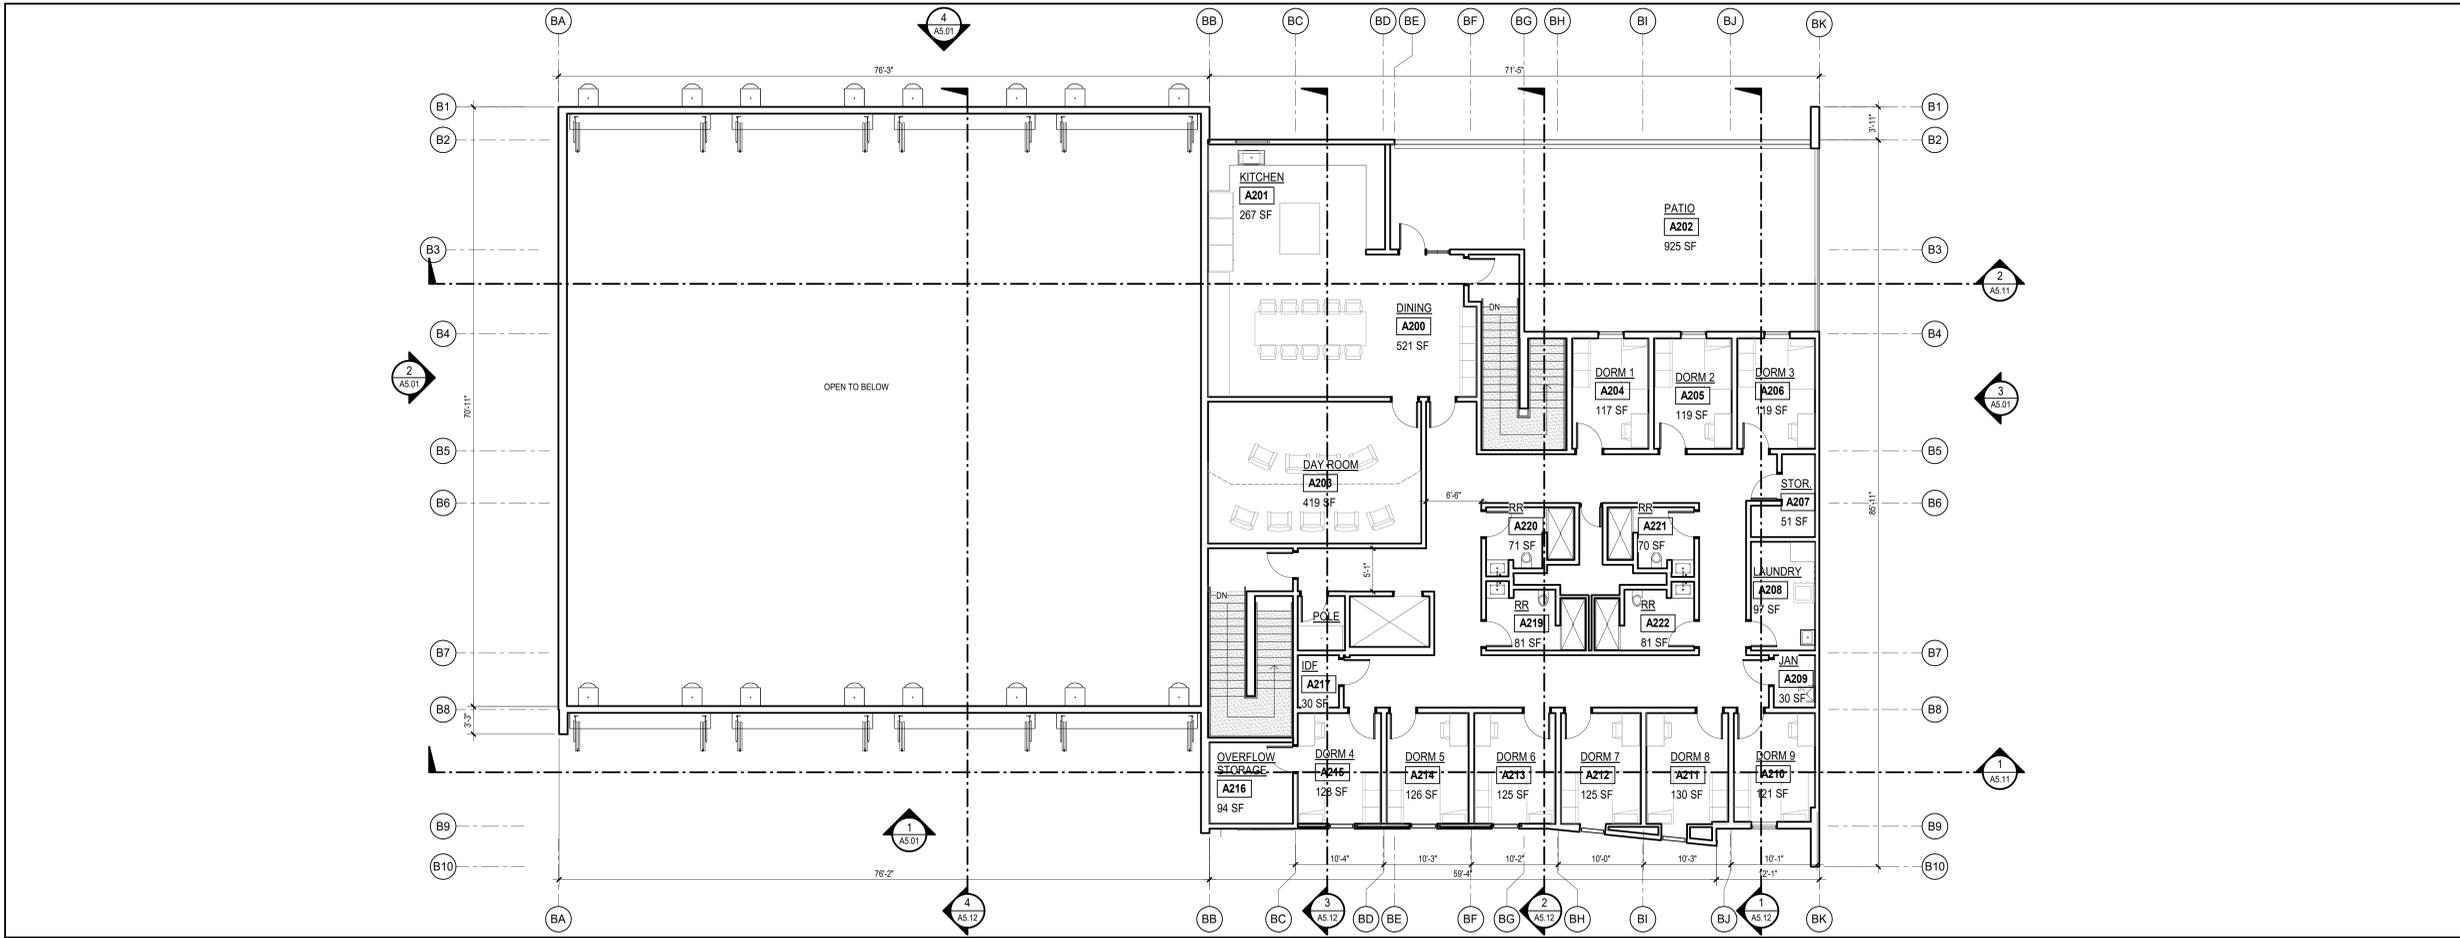

ARCHITECT PBK Architects, Inc.  
SAN LUIS OBISPO  
1327 Archer Street, Suite 110  
San Luis Obispo, CA 93401  
805-329-3076

**FIRE STATION #2**  
CITY OF SUNNYVALE

706 E. Arques Ave  
Sunnyvale, CA 94085  
SCHEMATIC DESIGN

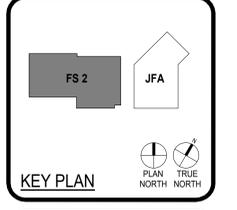

REVISIONS		
#	DESCRIPTION	DATE

CLIENT	CITY OF SUNNYVALE
PROJECT NUMBER	240010
DATE	11/5/2024
DRAWN BY:	DB
CHECKED BY:	CK

SCHEMATIC DESIGN  
**FLOOR PLAN  
FIRE STATION 2**

**A2.01**

11/6/2024 5:03:10 PM

This document is for plan review only